

Omaha, NE 68134

REVISION

No

DATE

www.specializedeng.com

OF RECORD	STAMP	APPROVED:	DATE:	APPROVED: PROJECT COR DATE:	:	APPROVED: PATIENT SAFETY DATE:	AF	PPROVED: EMS MANAGER DATE:	APPROVED: DIRECTOR FMS DATE:		PROJECT TITLE			date: 03/30/2022	
DERSON	I hereby certify that this plan, specification or report was prepared by me or under my direct supervision and that I am a duly Licensed Architect under the laws of the State of Minnesota.	APPROVED:		APPROVED: SERVICE LINE DIRECTOR DATE:	 : 	APPROVED: SAFETY MANAGER DATE:	AF	PPROVED: M/O MANAGER DATE:	APPROVED: ASSOCIATE DIRECTOR DATE:	BUILDING 108 COVER SHEET & SHEET INDEX	UPGRADI			PLOT SCALE PROJECT NO. 656-21-235	VΑ
N. #100 Plymouth, MN 55441	Name: Jourday	APPROVED:	DATE:	APPROVED: GEMS COORDINATOR DATE:		APPROVED: CHIEF OF POLICE DATE:		PPROVED: PROJECTS SECTION MANAGER DATE:	APPROVED: NURSE EXECUTIVE DATE:		BUILDING No 108	CHECKED BY	DRAWN EM	DRAWING NO. 108-GI000	
F 763 412 4090 J ae-mn com	Typed or Printed Name: <u>Tom Olesak</u> Date: <u>03/30/2022</u> License Number: <u>MN# 18157</u>		DATE:	APPROVED: INFECTION CONTROL NURSE DATE:	:	APPROVED: OIT MANAGER DATE:	AF	PPROVED: ASSISTANT CHIEF ENGINEER DATE:	 APPROVED: CHIEF OF STAFF DATE:	APPROVED: MEDICAL CENTER DIRECTOR DATE:	LOCATION VA MEDICAL CI ST.CLOUD, MN	ENTER 56303	FULLY SPRINKLERED	COVER DWG. OF	




U.S. Department of Veterans Affairs eterans Health dministration St. Cloud VA Health Care System

POSSIBLE ABATEMEI	NT ACTION							
ITILITY TUNNELS. INSTALLATION OF DISTRIBUTION SHALL NOT								
CHEDULE								
CONTROL ROCEDURE CLASS	SECTION	CONSTRUCTION ZONE / OCCUPIED CONSTR	DAY / NIGHT					
CLASS II AND CLASS SELEC	CENTER TED TO BES	OCCUPIED CONSTRUCTION T OF DESIGN TEAM'S KNOWLE	NIGHT DGE.					
EDULE								
LEAK PREVENTION BARRIER WATERPROOFING								
NT = INTERIOR. EXT)						
		<u> </u>						

REMARKS



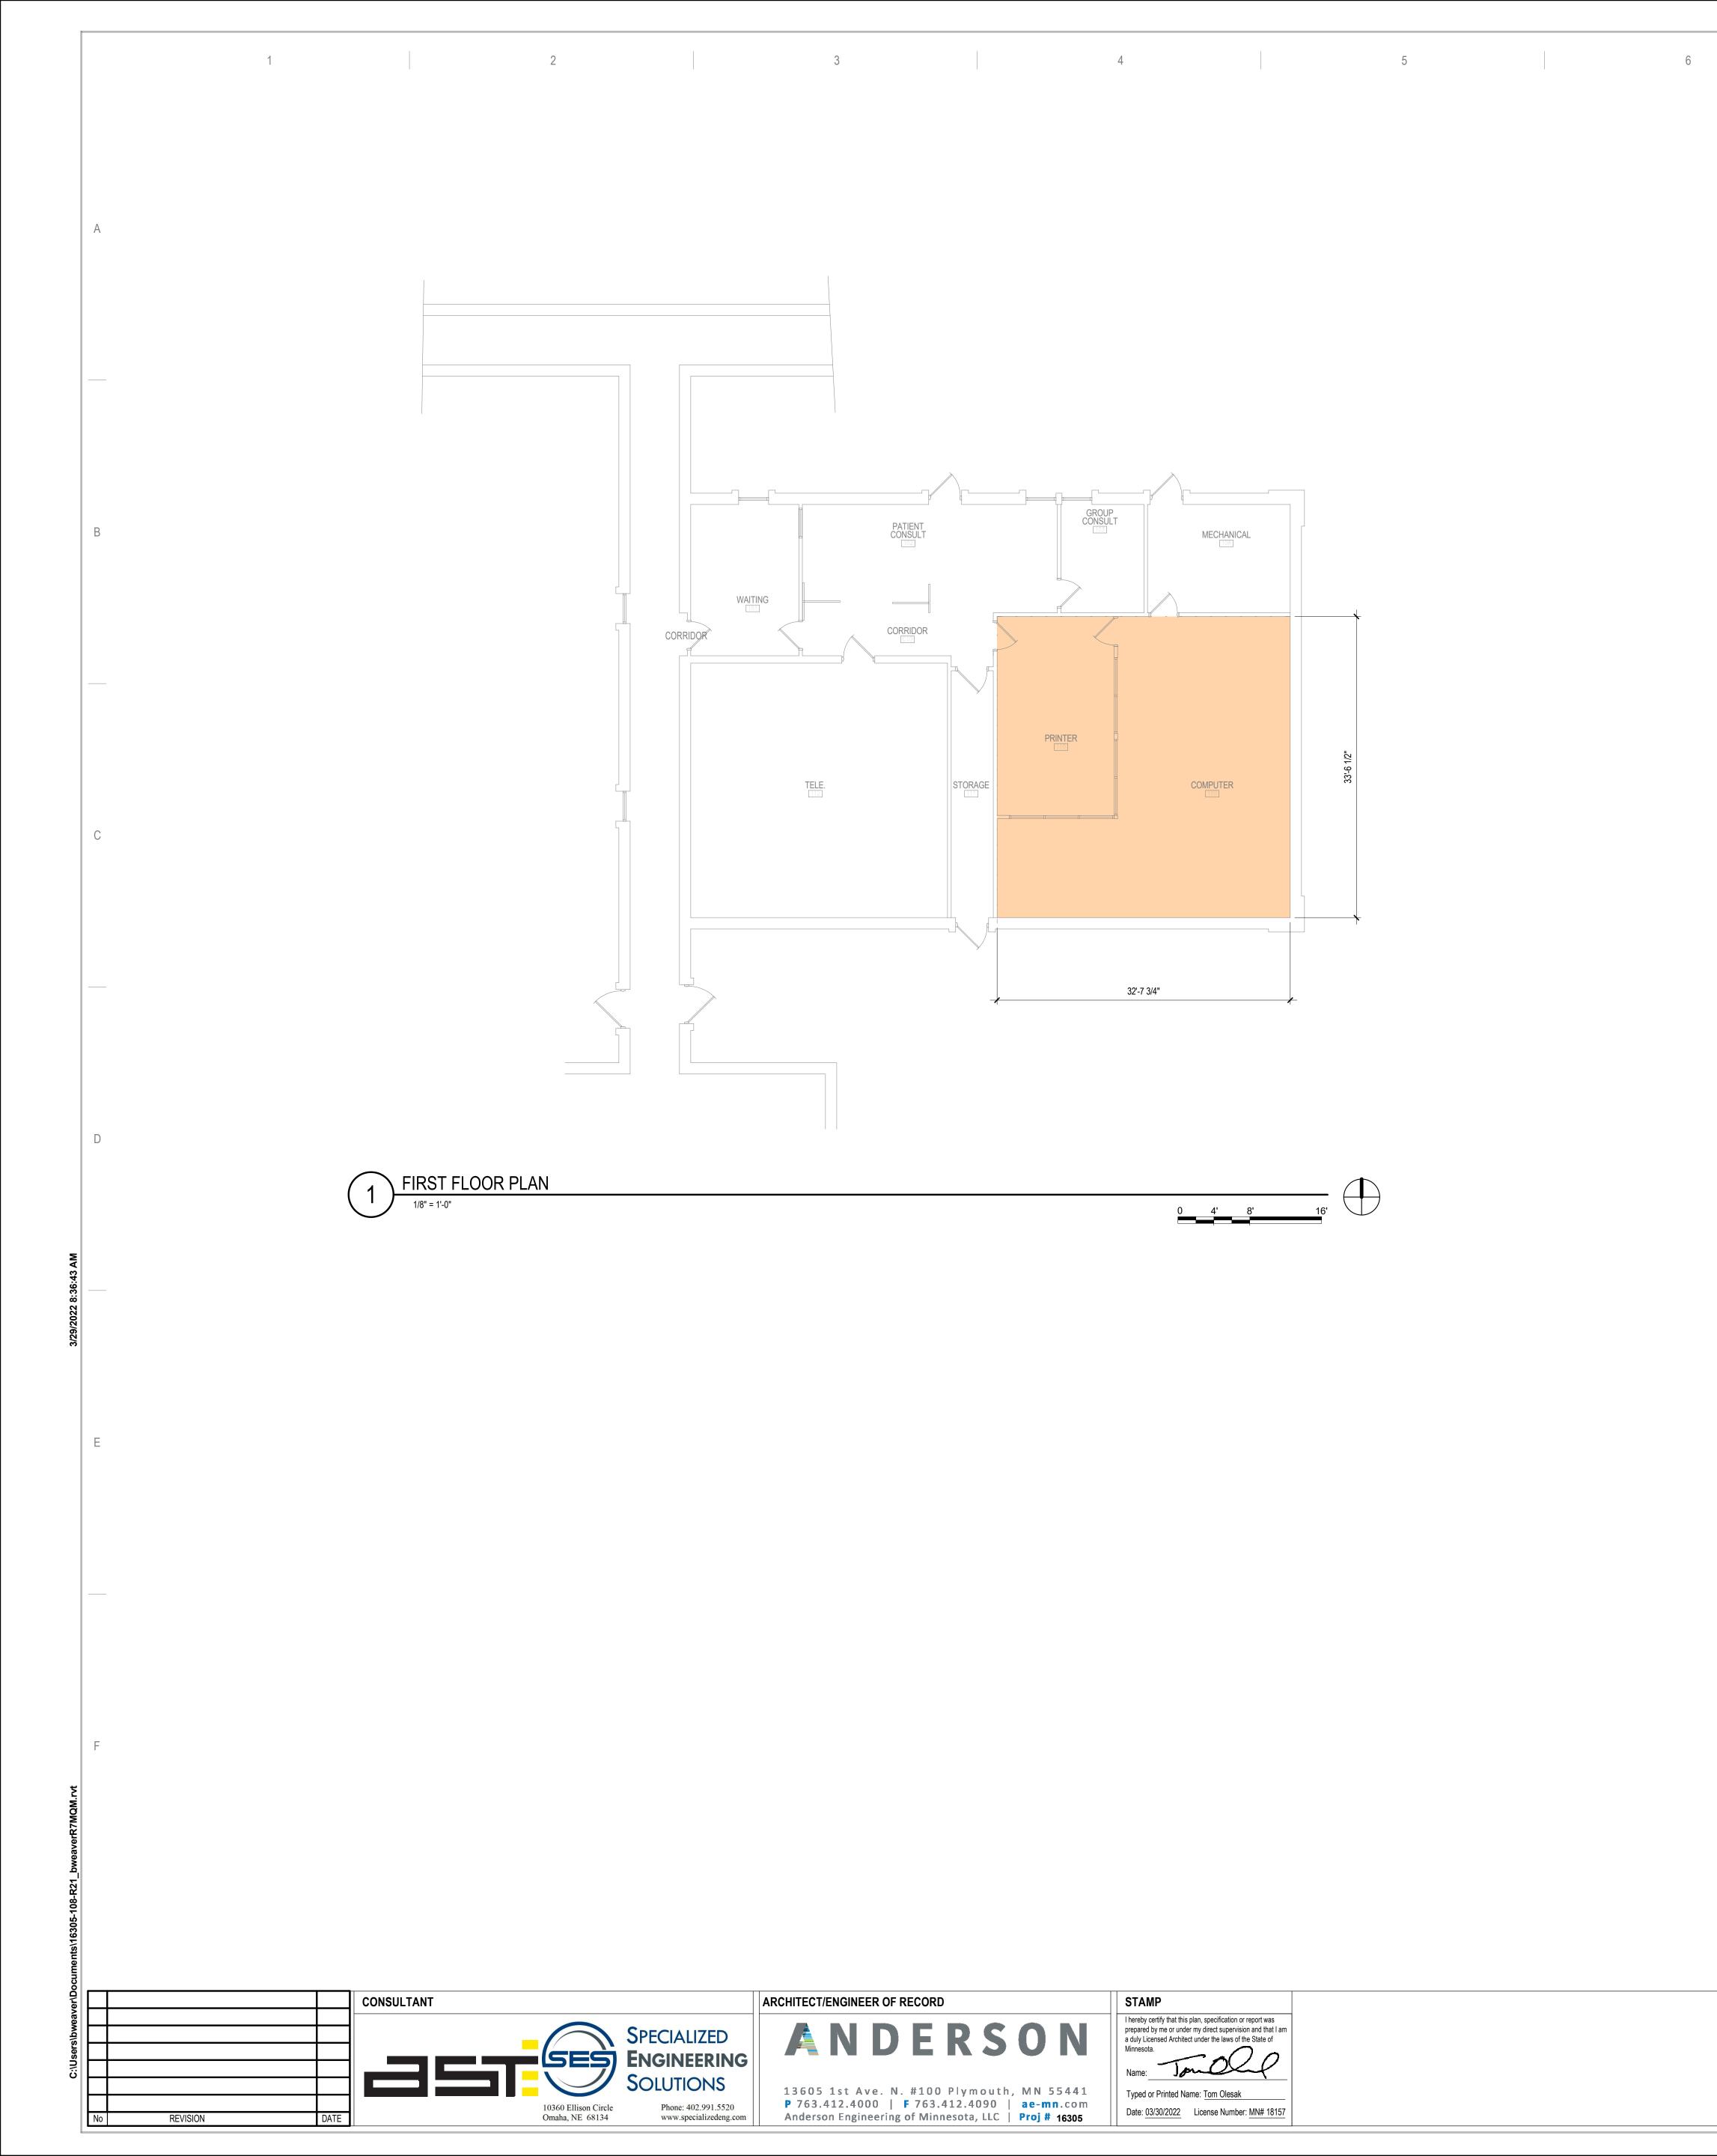

7	8	9	
			SHEET NOTES
			AL NOTES AND CAMPUS DRAWINGS FOR DN, LIFE SAFETY, ICRA, AND PHASING
		CONTRACTO	G CONDITIONS MUST BE FIELD VERIFIED OR PRIOR TO DEMOLITION OR CONSTRUC THAT DIFFER FROM THOSE SHOWN MUS 10N OF THE C.O.R. TO INFORM THE ARCH
		AND PHOTO	IATION SHOWN ON THE DRAWINGS IS BA GRAPHS PROVIDED BY THE C.O.R. COMB DNS AND SURVEYED DATA FROM THE AR
		PLUMBING D	TRUCTURAL, TELECOM, ELECTRICAL, ME RAWINGS AND SPECIFICATIONS FOR ADI I AND CONSTRUCTION REQUIREMENTS.
		DETERMINE	TRE EXTINGUISHERS (CO2 OR HALOGEN D BY VA) WITH WALL MOUNT BRACKET AN ALL BE PROVIDED BY THE CONTRACTOR

DRAWING TITLE FIRST FLOOR PLAN - OVERALL	PROJECT TITLE EHRM INFI UPGRADE		CTURE	DATE: 03/30/2022 PLOT SCALE	
				PROJECT NO. 656-21-235	VA
	BUILDING No 108	CHECKED BY	DRAWN EM	DRAWING NO. 108-AS110	
	LOCATION VA MEDICAL CEI ST.CLOUD, MN 5		FULLY SPRINKLERED	DWG. OF	

TES

S DRAWINGS FOR GENERAL , AND PHASING

BE FIELD VERIFIED BY THE TION OR CONSTRUCTION. EXISTING THOSE SHOWN MUST BE BROUGHT TO O INFORM THE ARCHITECTS AND

HE DRAWINGS IS BASED ON DRAWINGS 3Y THE C.O.R. COMBINED WITH DATA FROM THE ARCHITECTS AND

DM, ELECTRICAL, MECHANICAL, AND IFICATIONS FOR ADDITIONAL N REQUIREMENTS.

© (CO2 OR HALOGENATED TYPE AS MOUNT BRACKET AND CODE REQUIRED Y THE CONTRACTOR WITHIN TELECOM



U.S. Department of Veterans Affairs Veterans Health Administration *St. Cloud VA* Health Care System